#### Project Narrative

Site Location is a second floor (third story) condo unit in the Seaplace Association at 1945 Gulf of Mexico Dr Unit M2-204, Longboat Key, FL 34228. The Proposed Project is a remodel of the entire unit. This will involve demo and removal of all finishes and fixtures, new layout of Kitchen, Master Bath, and Laundry; and new finishes throughout. All concrete ceilings will be hat-tracked with

new drywall, and all soffits will be raised as much as possible. All changes made will exist within the interior of the unit.

Total Conditioned Space: 1578sf Impacted Area: 1578sf

Wind Load: 150mph Risk Category II Exposure Category D

Alteration Level 2

#### Scope of Work

General Items

Hat track all concrete ceilings, drywall

New flooring throughout

New doors and millwork throughout

### Kitchen

Full Demo

Demo dividing walls to living and entry for open concept

Raise ceiling soffit +/- 10"-12"

Relocate sink and appliances

Install new cabinetry and countertops

Install new appliances and fixtures

#### Master Bath

Full Demo

Demo and reframe interior walls to create walk-in closet

Install new cabinetry and countertops

Install new tile shower and fixtures

#### Guest Bath

Full Demo

Install new cabinetry and countertops

Install new tile shower and fixtures

Close off doorway to living room

Install new desk cabinetry and tops

#### MEP


Reorient rough-in plumbing to accommodate plans Update Plumbing connections where necessary

Update Electrical circuits where necessary

Reorient and add circuitry to accommodate plans Update Smoke Detectors to meet code


Update HYAC supplies and returns where necessary

Electrical Panel - No Change

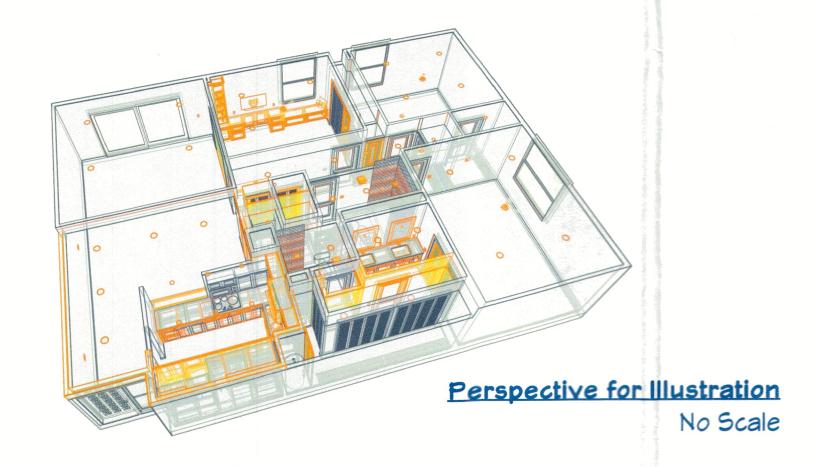

# Dotter Remodel

## Creative Kitchens and Baths

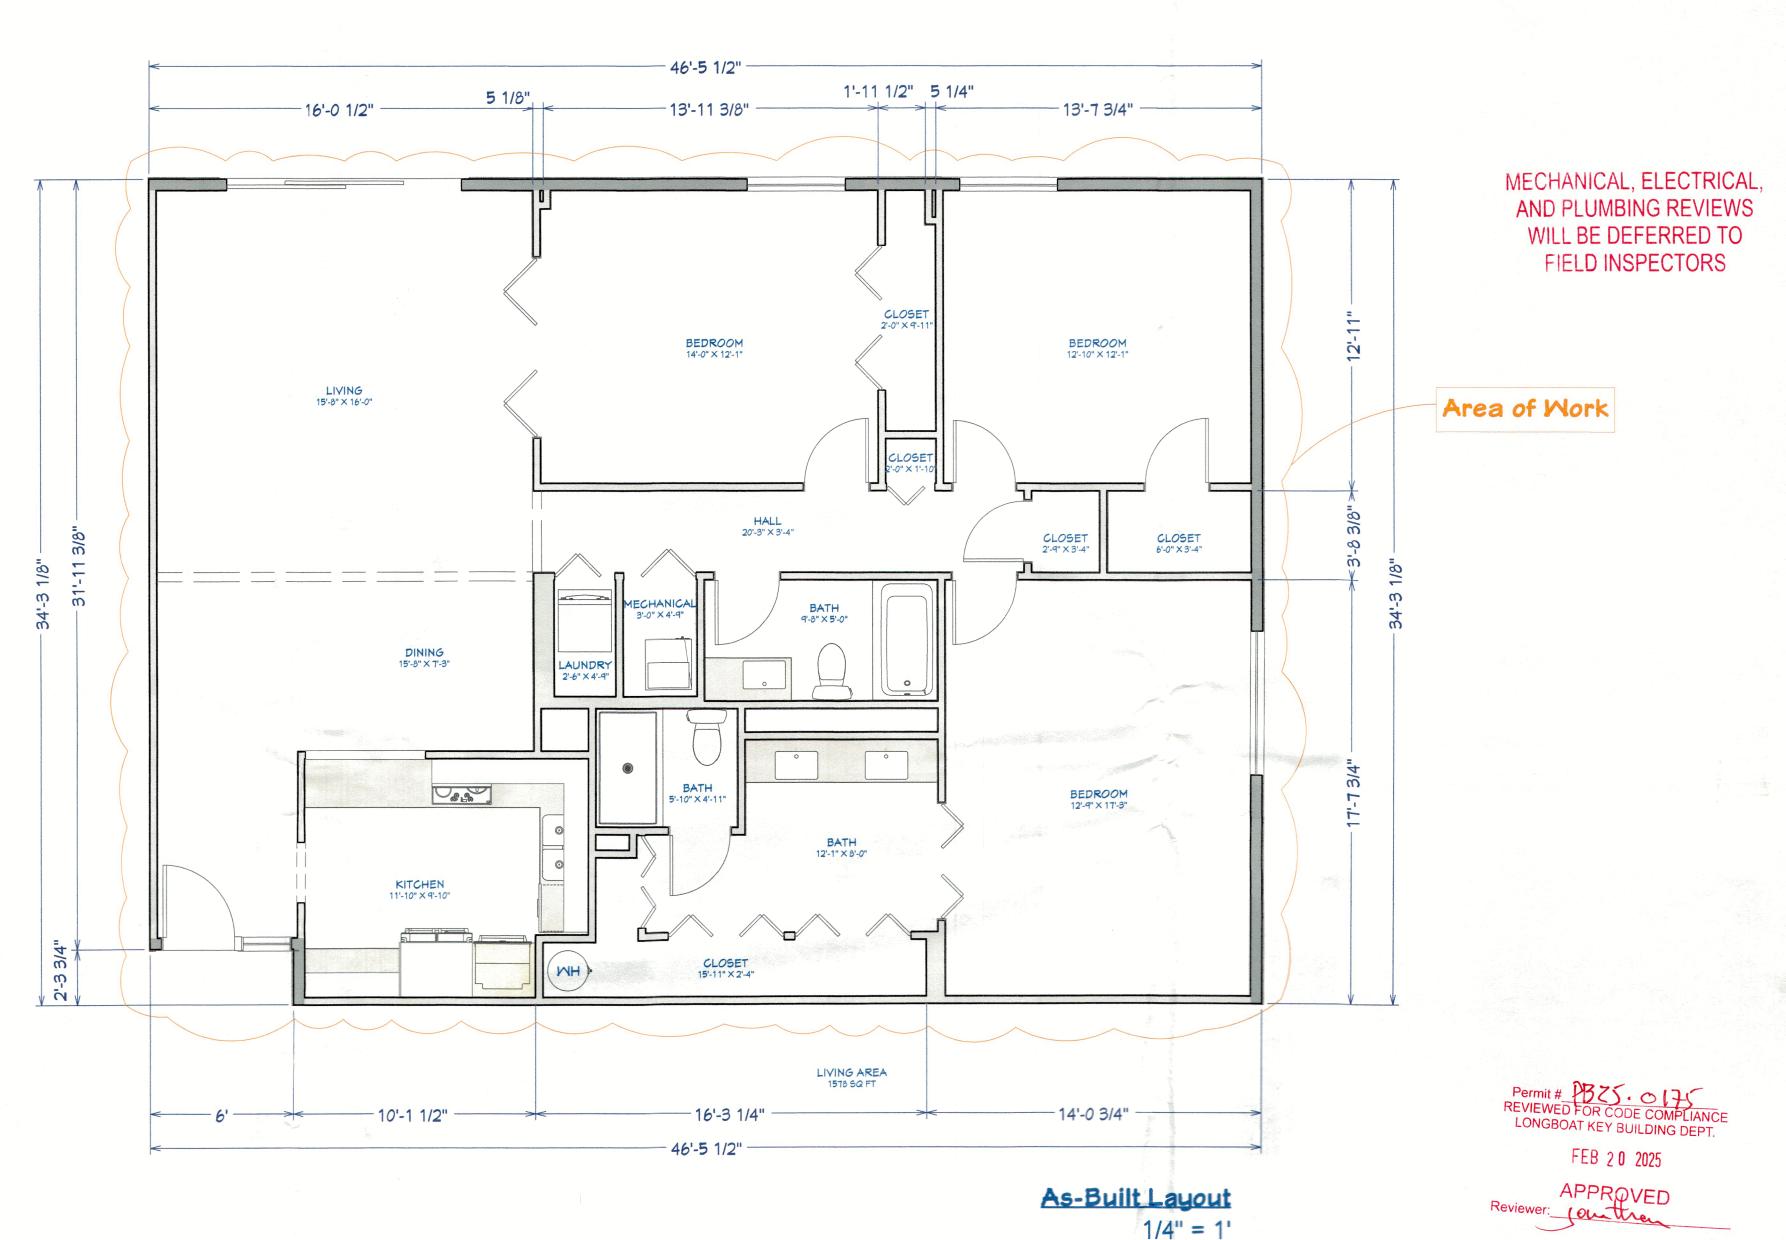

_abe	Title	<b>Description</b> Comments
4-1	Scope of Work	
4-2	Layout Changes	
4-3	Demo / Framing Plan	
<b>AE-1</b>	Switching / Receptacle Layout	
	Lighting Layout	
AP-1	Plumbing Layout	
4-4	Cabinetry Layout / Kitchen	
<b>A-5</b>	Cabinetry Layout / Den & Bathrooms	
	Finish Schedule	

THESE DRAWINGS ARE THE PROPRIETARY WORK PRODUCT AND PROPERTY OF CREATIVE KITCHENS & BATHS, DEVELOPED FOR THE EXCLUSIVE USE OF CREATIVE KITCHENS & BATHS. USE OF THESE DRAWINGS AND CONCEPTS CONTAINED THEREIN WITHOUT THE WRITTEN PERMISSION OF CREATIVE KITCHENS 8 BATHS IS PROHIBITED AND MAY SUBJECT YOU TO A CLAIM FOR DAMAGES.

Snoozehounds Renovations, Inc. Building Code: DBA Creative Kitchens & Baths 5610 Gulf of Mexico Drive, Unit 1 Longboat Key, FL 34228 941-925-3723 (Office) 407-304-9727 (Mobile) Plans by Ryan Levar Licensed CGC - Bruce Smith License # CGC 1531837

Mechanical Code: Electrical Code: Plumbing Code: Fire Safety Code: Classification of Work: Building Type:

Sprinklered:

Residential Single Family

Yes

BLDG PERMIT PLANS FILE @ 24" × 36" Florida Building Code (FBC) Eighth Edition (2023) with Applicable Amendments FBC Mechanical Eighth Edition (2023) with Applicable Amendments FBC, Chapter 27: 2020 National Electrical Code (NFPA 70) with Applicable Amendmentspy of Record

FBC Plumbing Eighth Edition (2023) with Applicable Amendments Florida Fire Prevention Code (FFPC) Eighth Edition (2023) with Applicable Amendments Alteration Level 2 RECEIVED

TANI 2 9 2025

A-1




40 cope S


d Bg Creative Kitchens and 5610 Gulf of Mexico I Longboat Key, FL

DATE: 1/20/2025

SCALE:

SHEET:

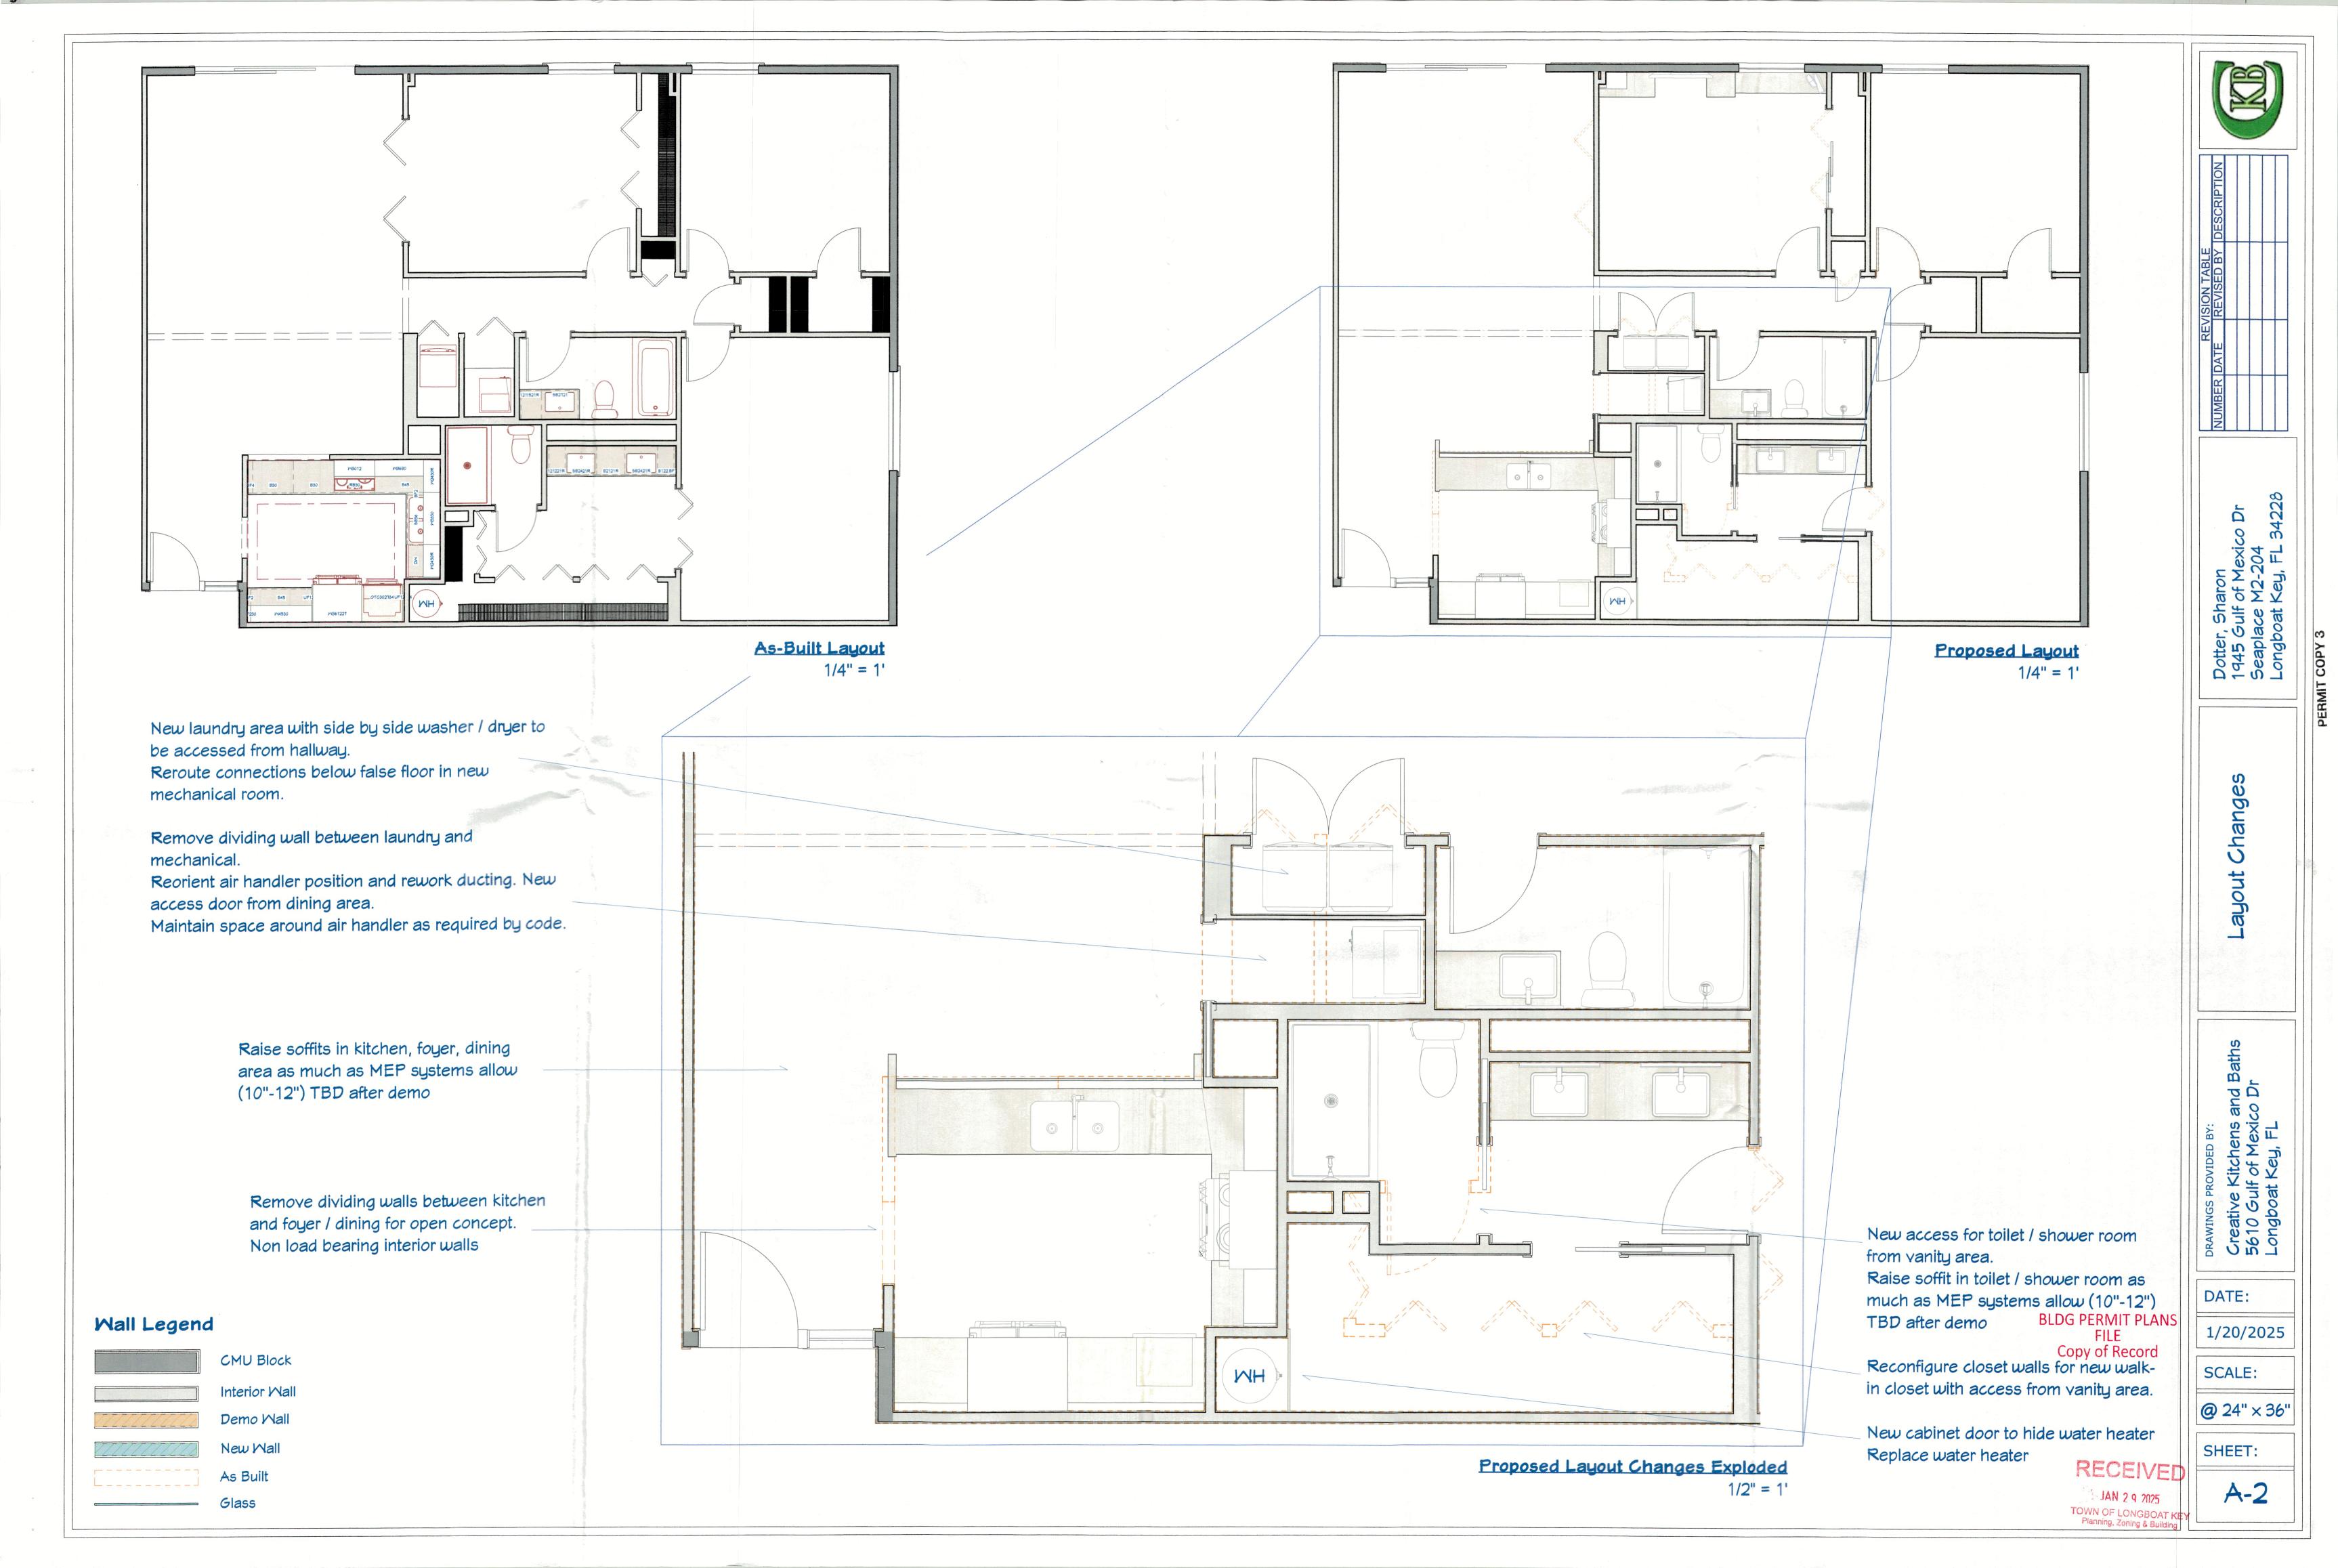

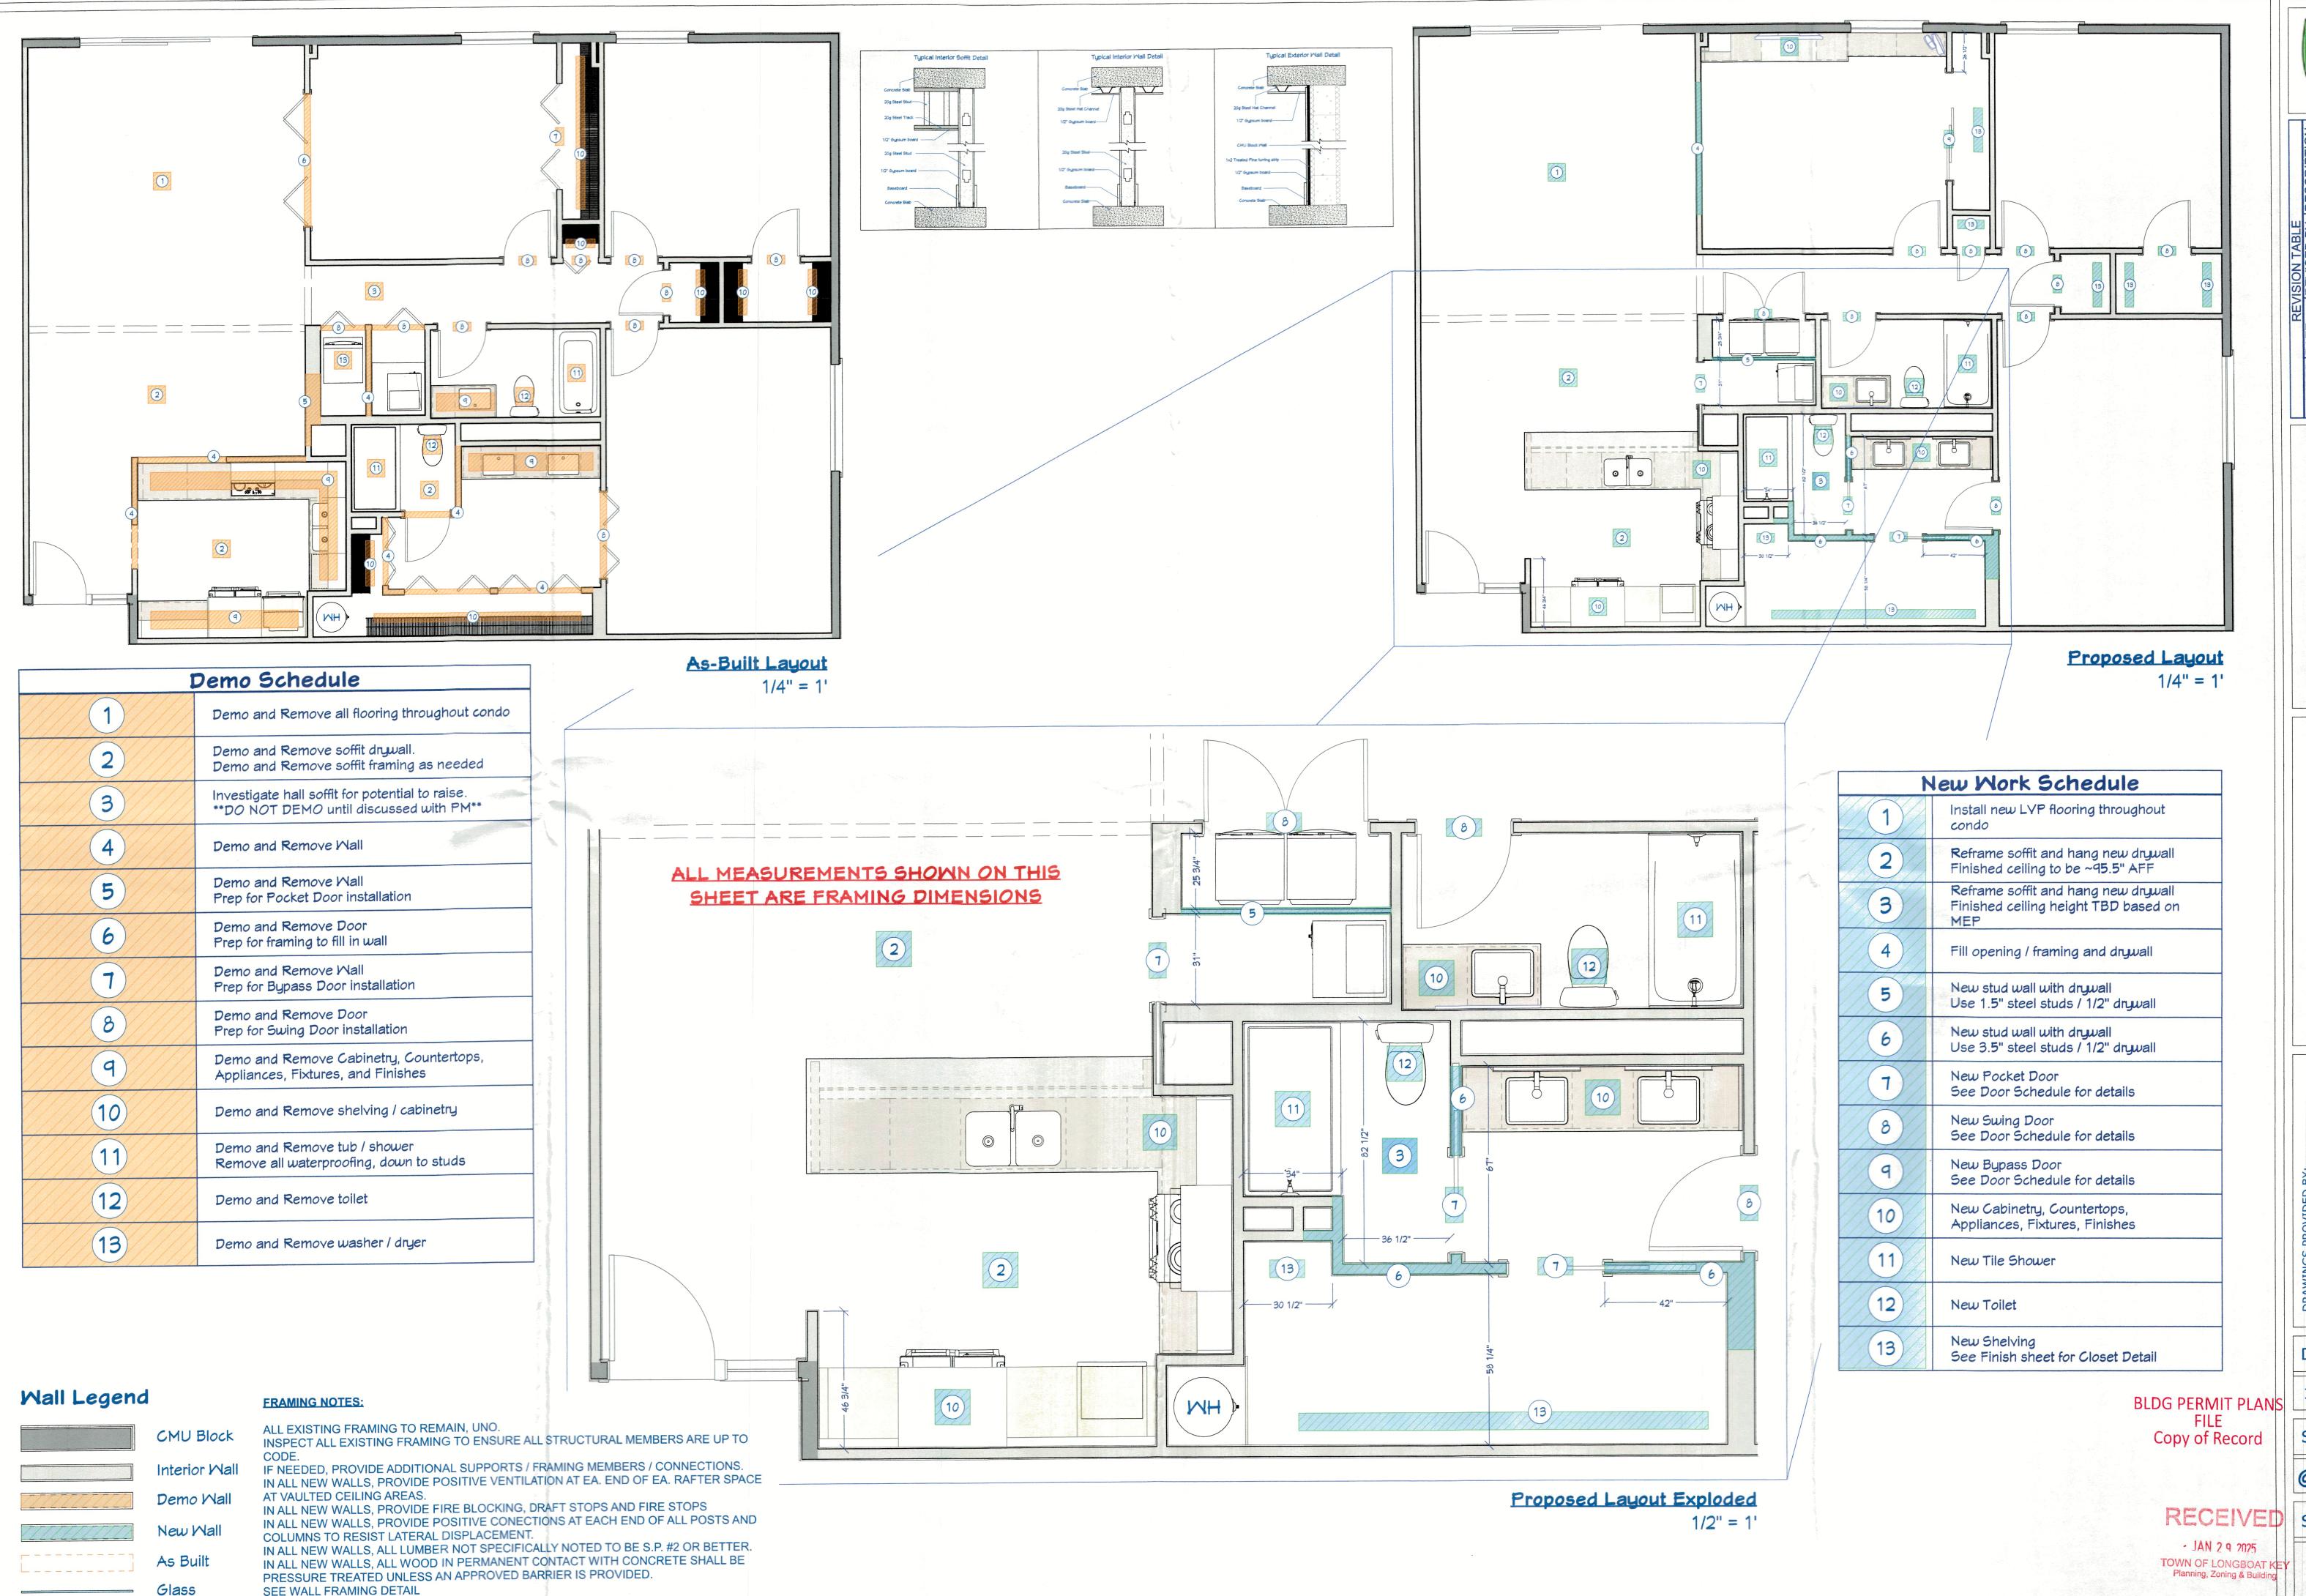

emo

Creative Kitchens and E 5610 Gulf of Mexico Dr Longboat Key, FL

DATE:


1/20/2025


SCALE:


@ 24" × 36"

SHEET:

A-3

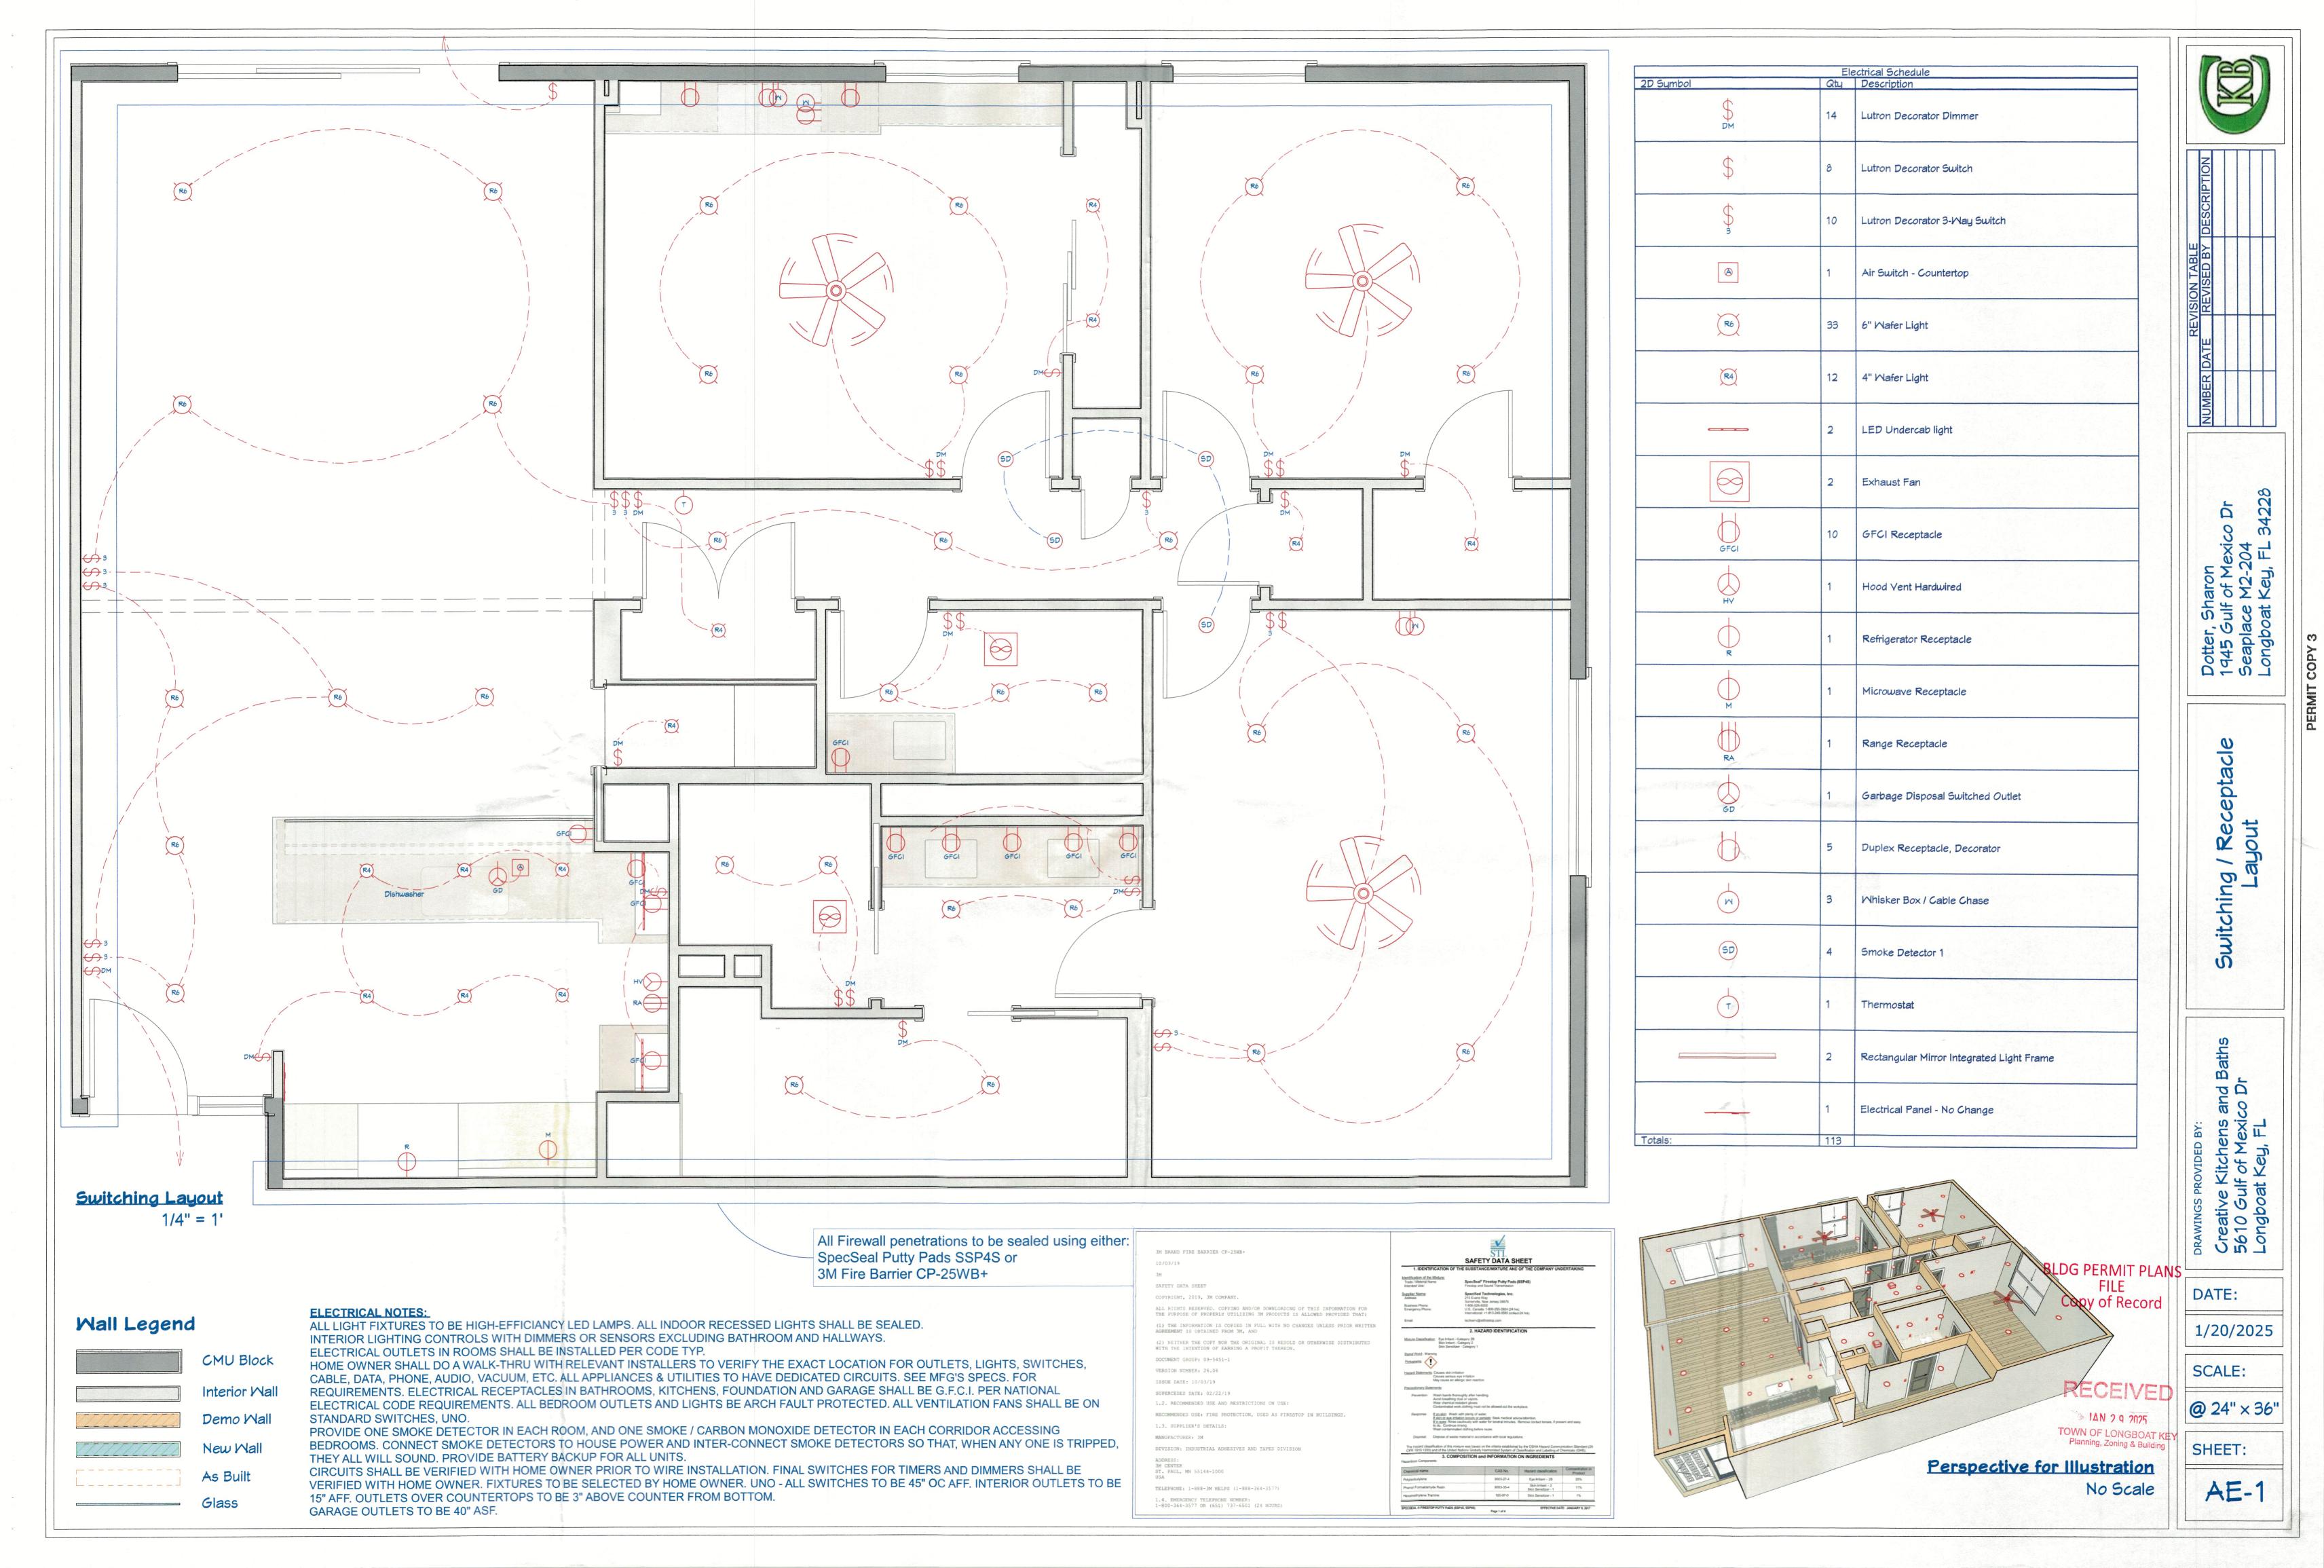

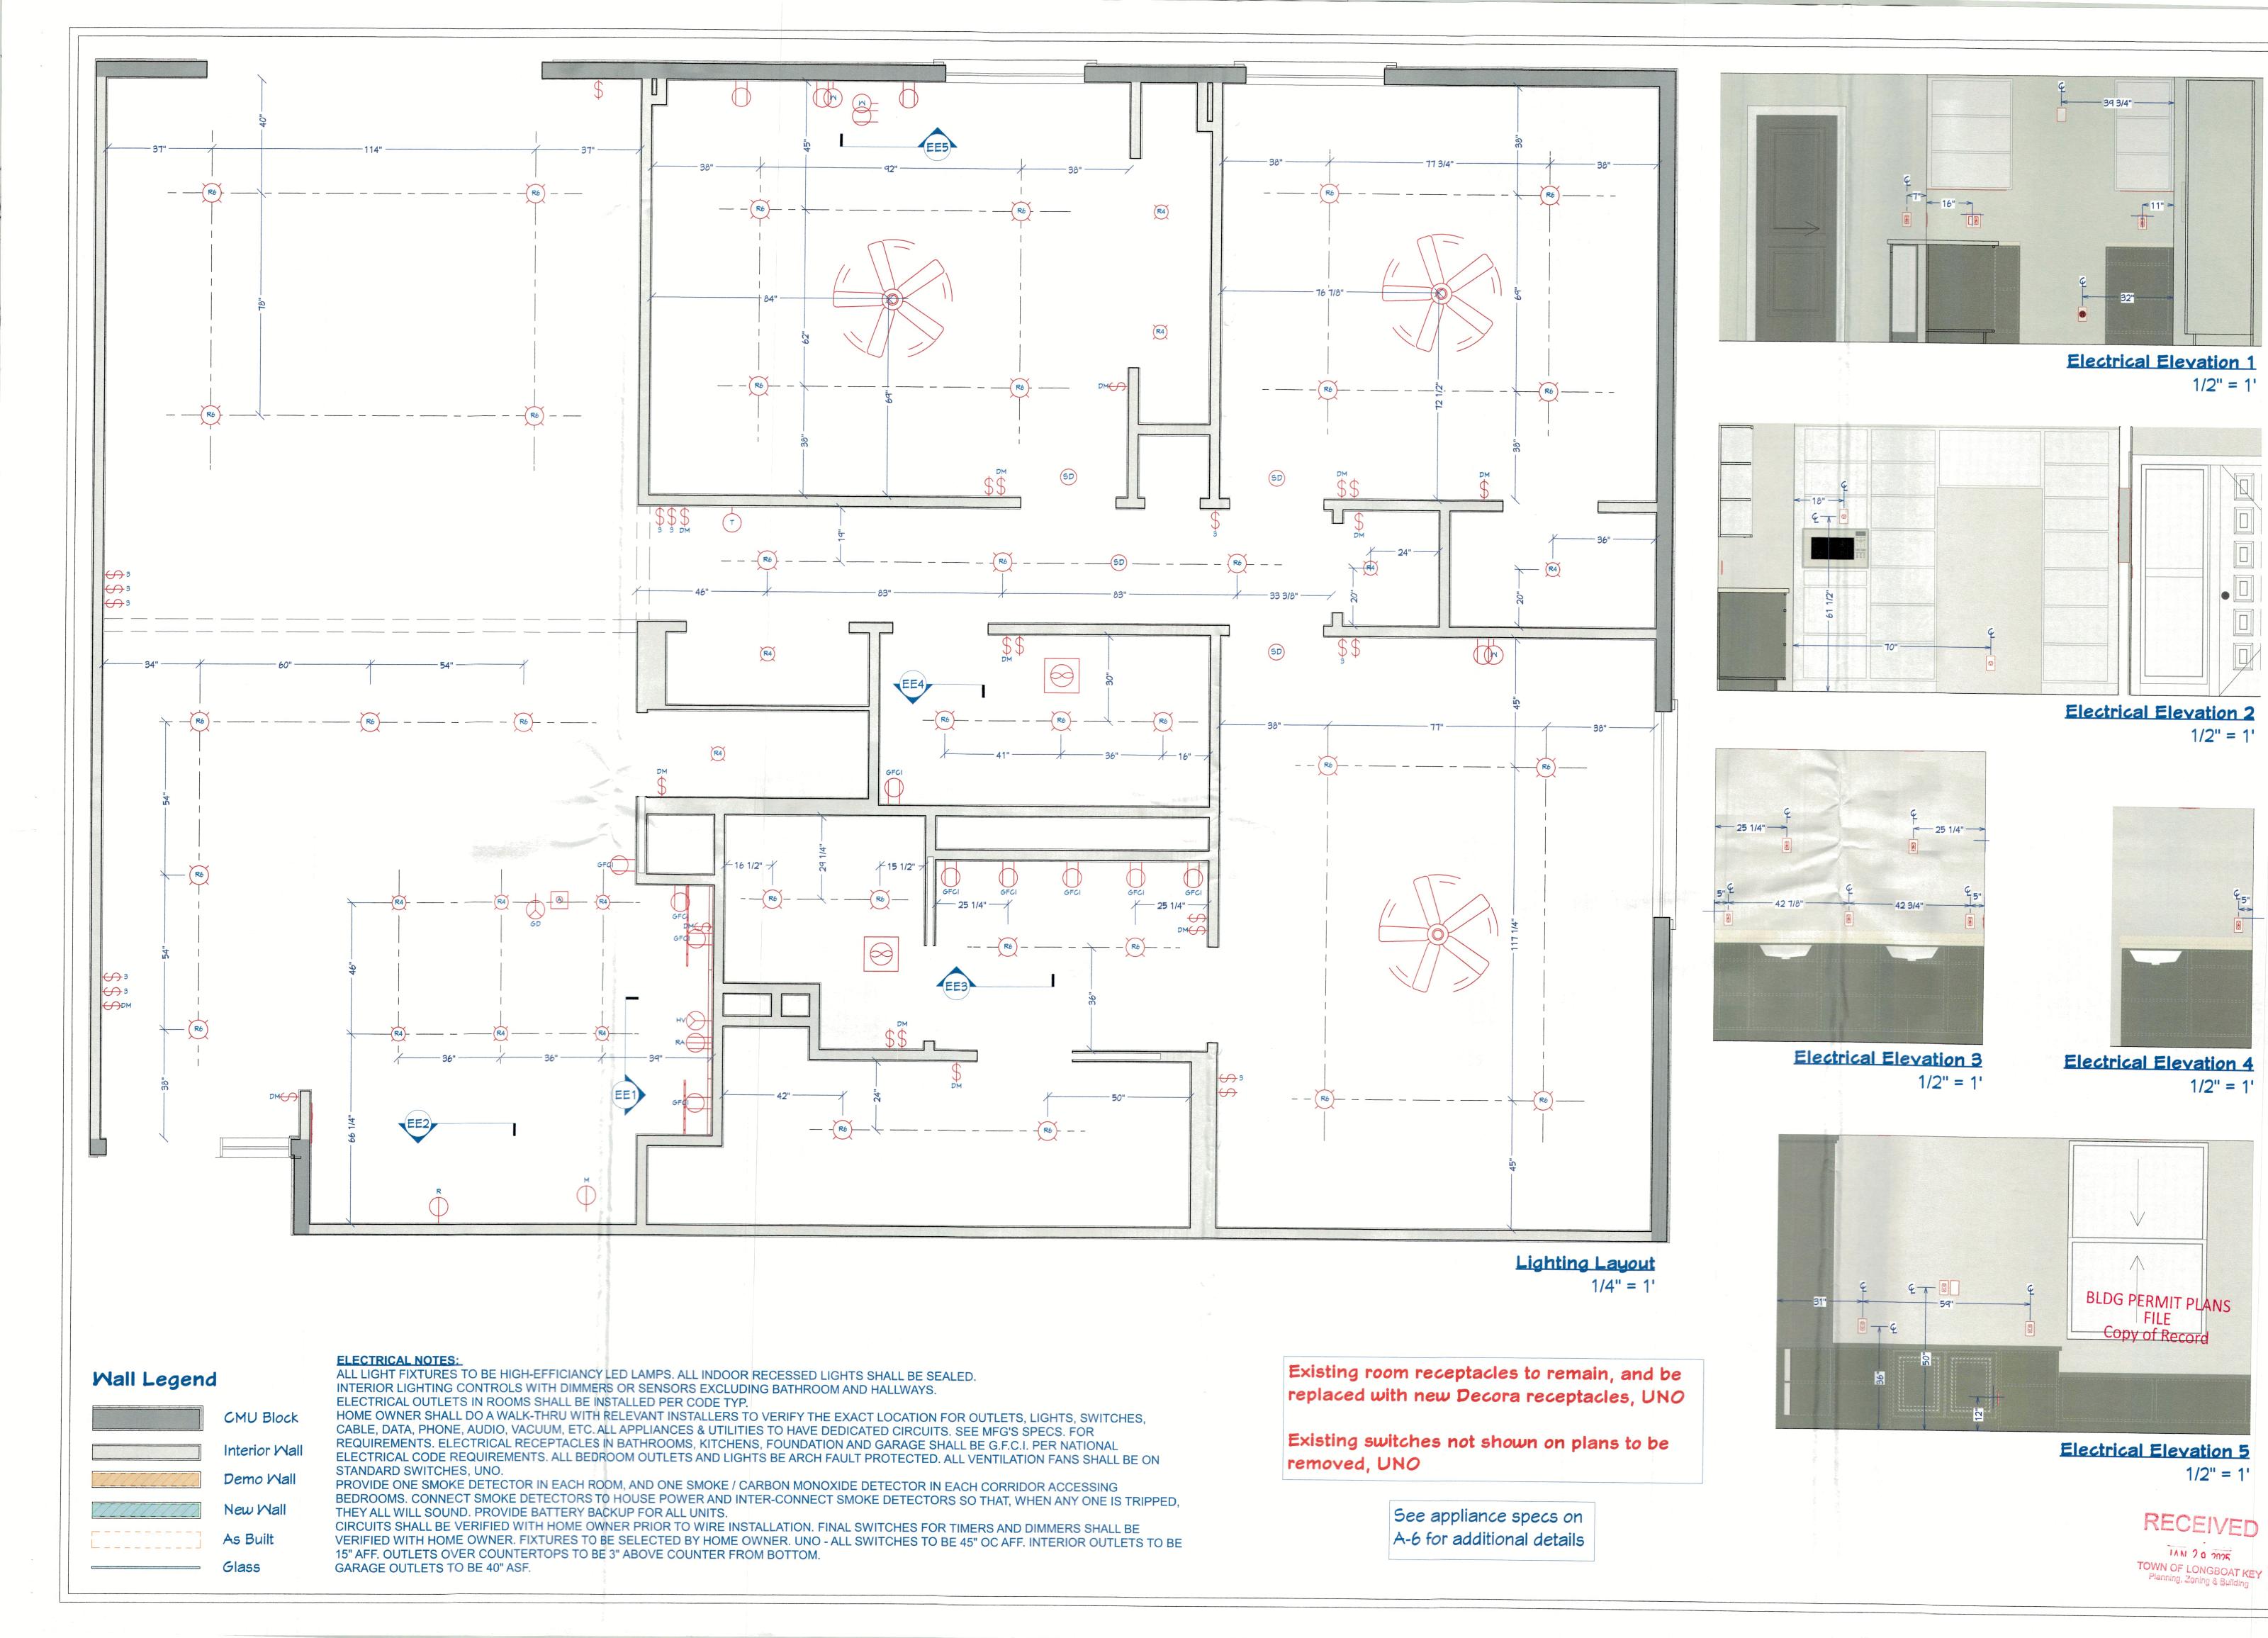

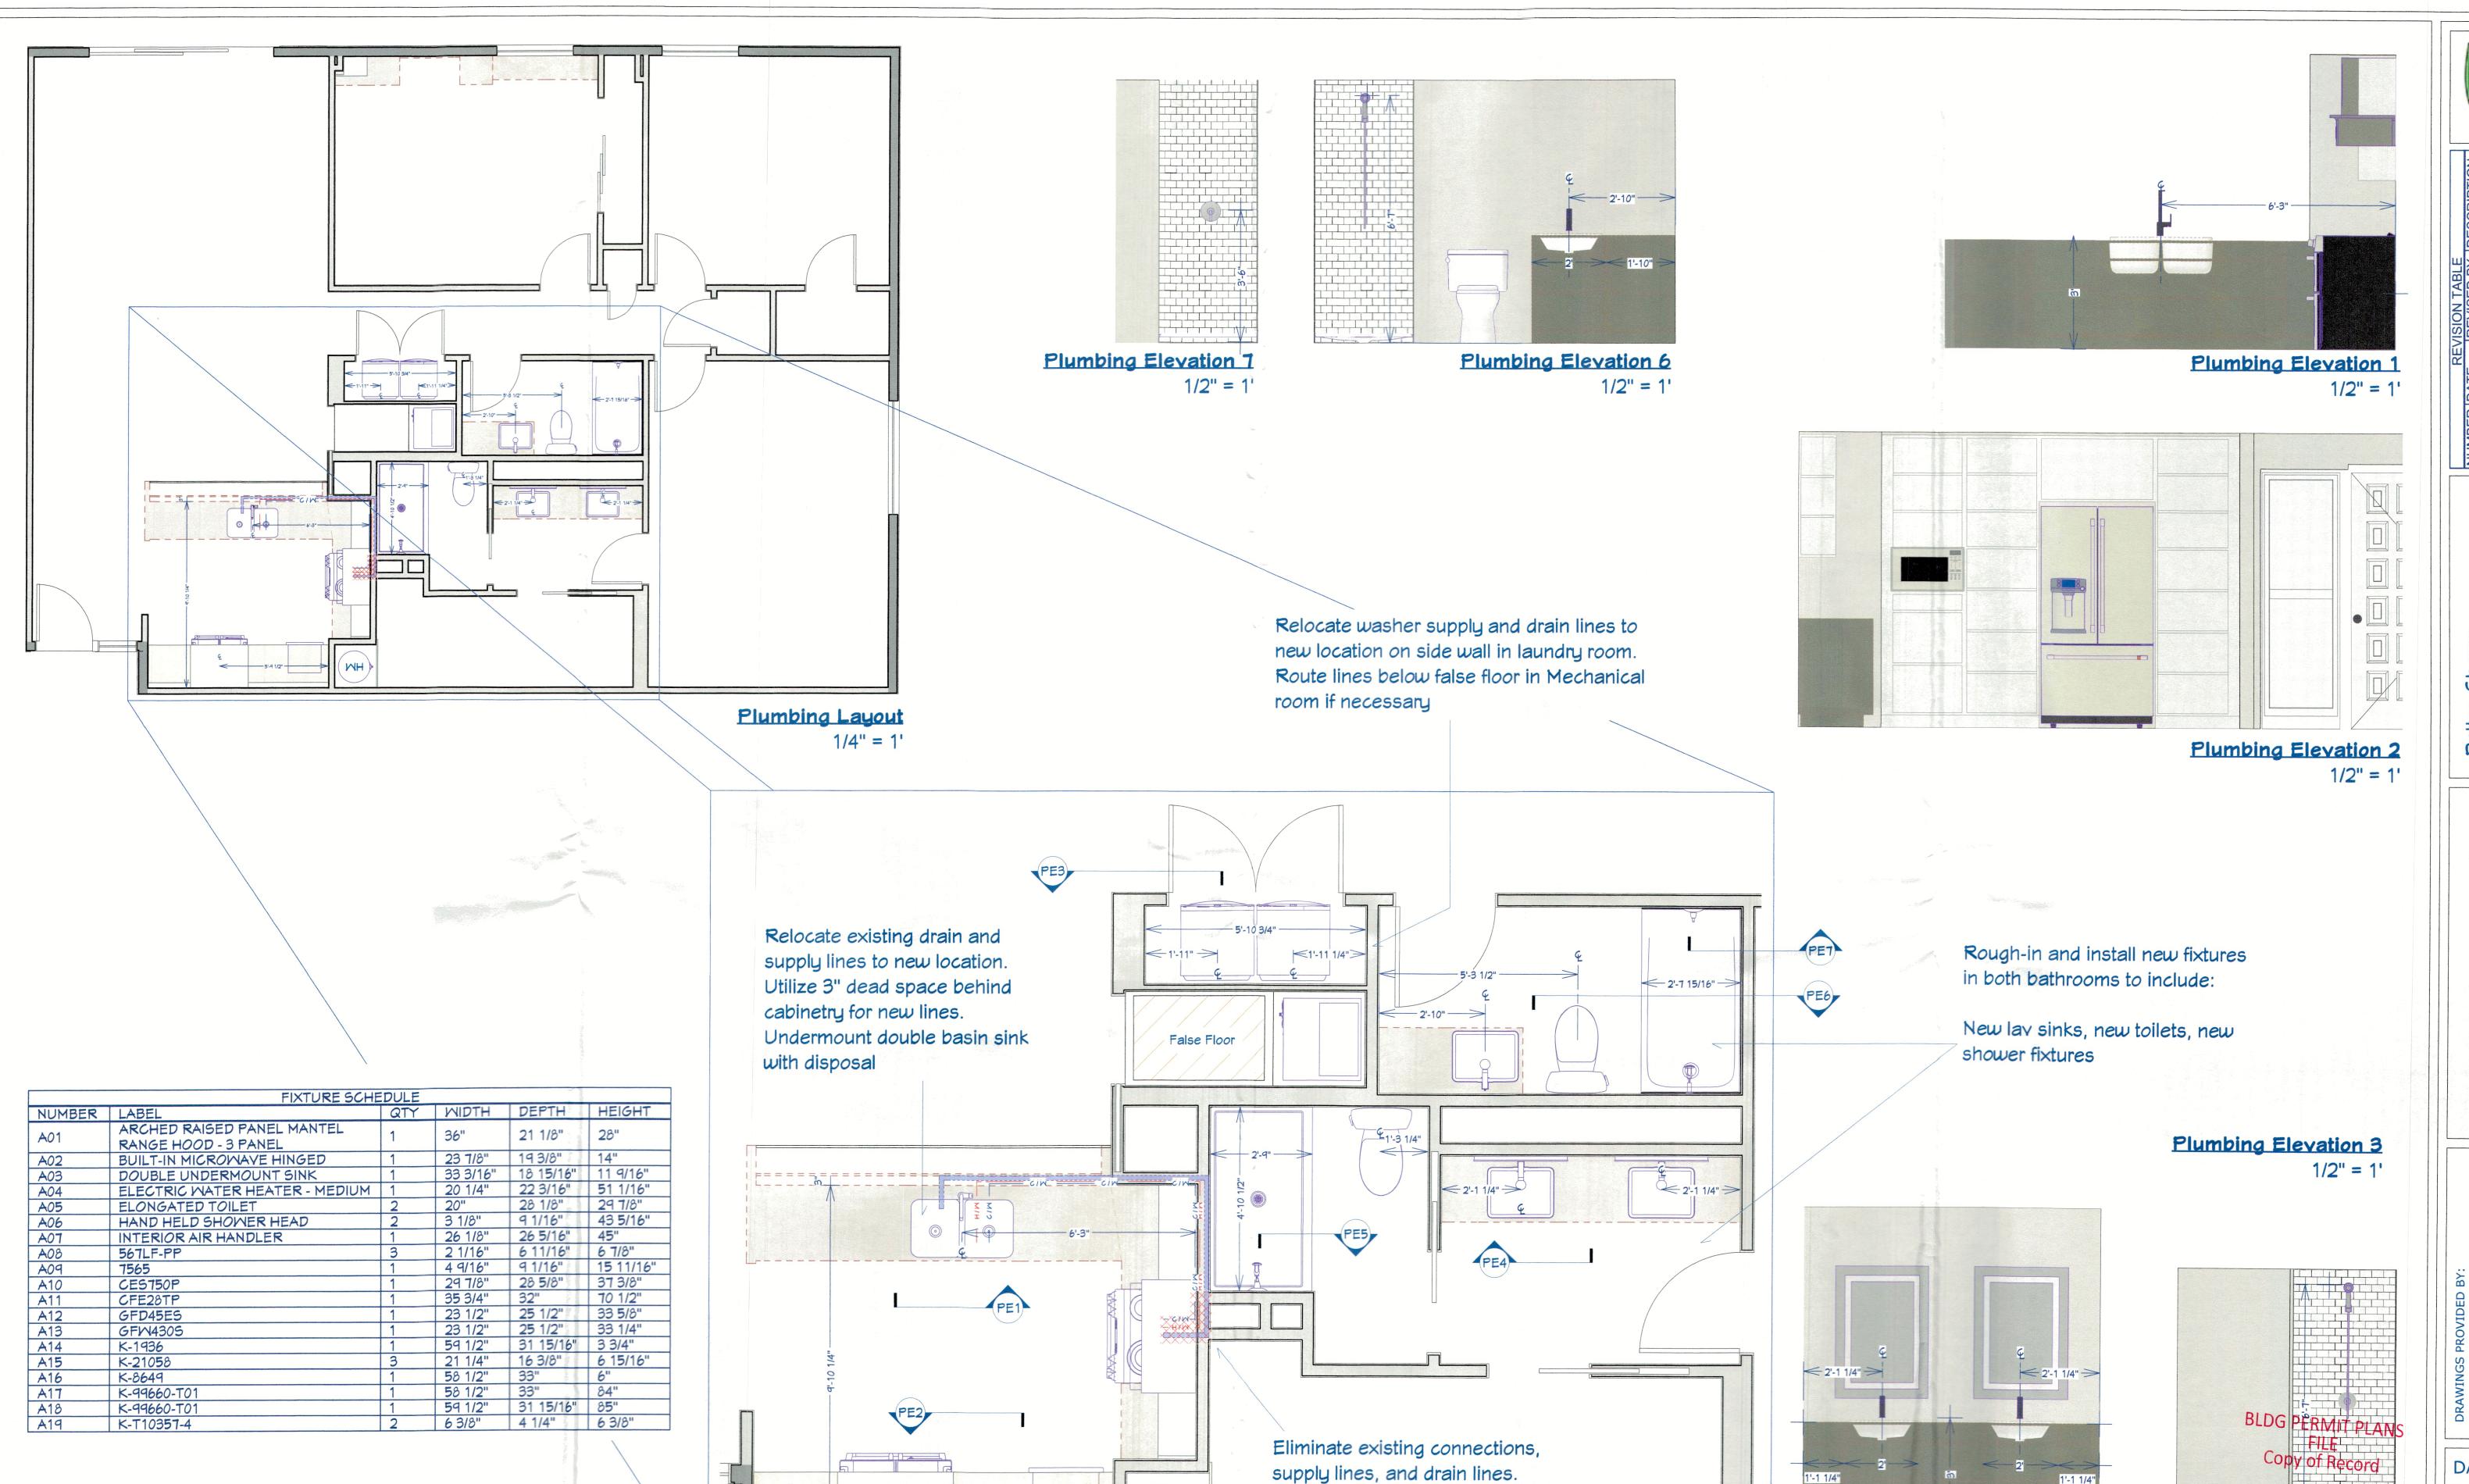

Relocate fridge supply line from existing location.

Install new recessed shut-off box

Cap and remove as necessary

Plumbing Layout Exploded

1/2" = 1'

Wall Legend

CMU Block

Interior Mall

Demo Wall

New Wall

As Built

Glass

**GENERAL PLUMBING & HVAC NOTES:** 

WITH A BACK DRAFT DAMPER.

PREVENTION DEVICE.

1. DRYER, WATER HEATER, KITCHEN AND BATHROOM VENTING SHALL

EXHAUST TO THE OUTSIDE OF THE BUILDING AND BE EQUIPPED

2. TUBS/SHOWERS SHALL BE PROVIDED WITH INDIVIDUAL CONTROL

VALVES OF THE PRESSURE BALANCE OR THE THERMOSTATIC MIXING TYPE. THE WATER TEMPERATURE SHALL BE AT A MAXIMUM

4. HEAT DUCTING SHALL BE SECURED, SEALED AND INSULATED AS

5. INSTALL WATERPROOF GYPSUM BOARD AT ALL WATER SPLASH

3. EACH HOSE BIBB SHALL BE EQUIPPED WITH A BACK FLOW

AREAS TO MINIMUM 70" ABOVE SHOWER DRAINS.
6. INSULATE WASTE LINES FOR SOUND CONTROL.

1945 Gulf Seaplace Longboat

Plumbing Layout

tchens and Baths of Mexico Dr Sey, FL

Creative Kitchens a 5610 Gulf of Mexic Longboat Key, FL

DATE:

1/20/2025

SCALE:

Plumbing Elevation 5

1/2" = 1'

RECEIVED

IAN 20 2025

TOWN OF LONGBOAT KEY Planning, Zoning & Building


Plumbing Elevation 4

1/2" = 1'

@ 24"×36"

SHEET:

AP-1

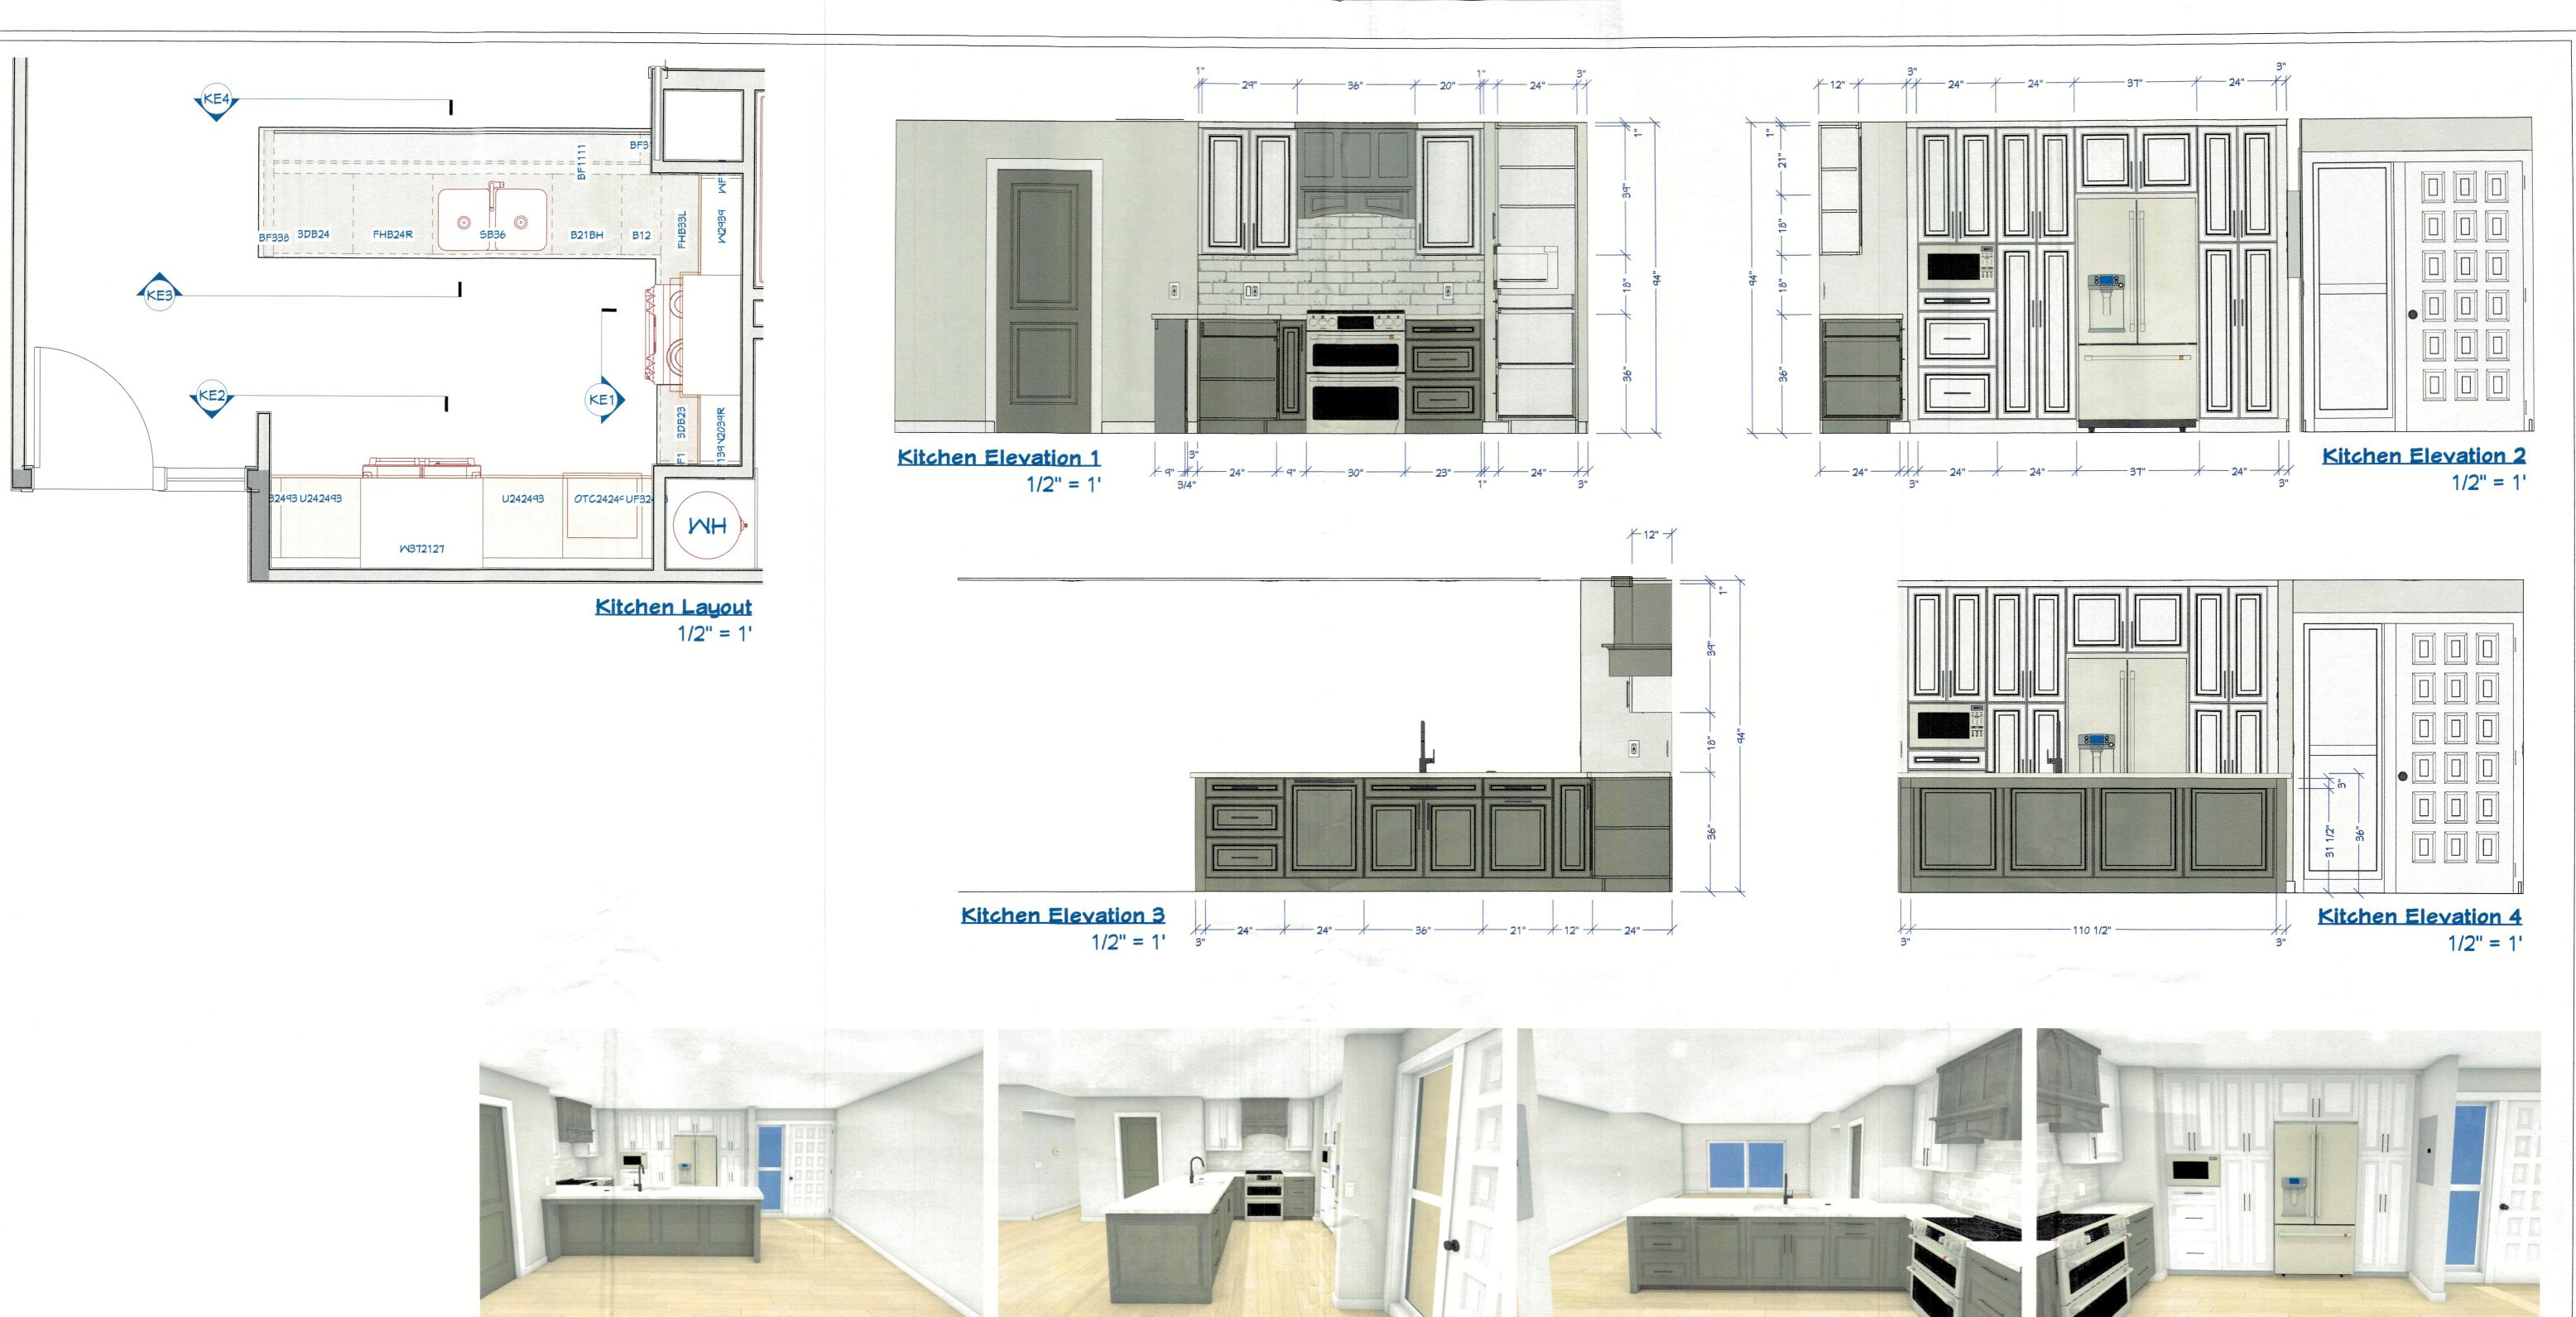



Renderings for Illustration No Scale



CMU Block

Interior Wall

Demo Mall

New Wall

As Built Glass

CABINETRY NOTES:

1. ALL CABINETS IN MAPLE CONFIRM COLOR WITH HOME OWNER PRIOR TO


2. ALL CABINETRY TO BE ATTACHED WITH 2 1/2" WOOD SCREWS TO STUDS. 3. INSTALL BACKING MATERIAL WHERE NECESSARY

4. ALL SCREW HEADS TO BE COVERED WITH FASTCAPS. ALL NAIL HOLES TO BE FILLED AND PAINTED TO MATCH.
5. CONFIRM DOOR & DRAWER STYLES WITH HOME OWNER PRIOR TO ORDERING.


6. INSTALL HARDWARE ON SITE.

7. INSTALL CROWN MOLDING ON SITE; MATCH CABINET COLOR; CONFIRM PROFILE AND DIMENSION WITH HOME OWNER.

8. CONFIRM FINAL MATERIALS FOR BACKSPLASH AND COUNTERTOP WITH HOME OWNER PRIOR TO ORDERING

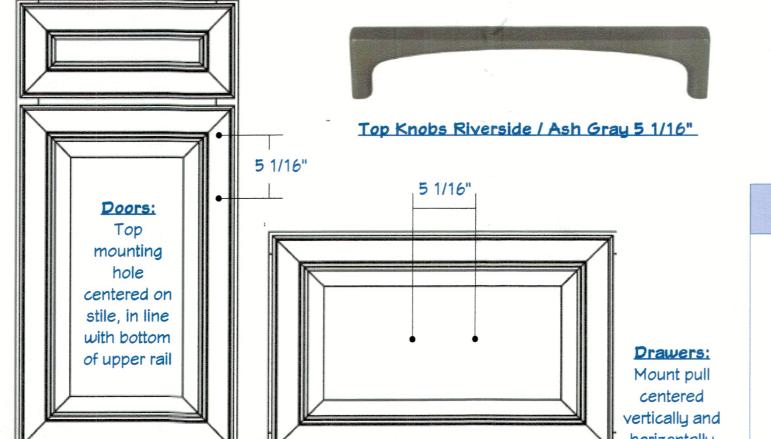

Door Style: York Raised Panel

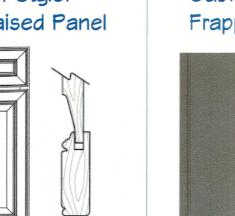



Cabinet Finish: Sea Salt / Maple

Kitchen Cabinetry Selections

Cabinet Finish: Peppercorn / Cherry

Countertop: Cambria Whitendale

AL WINE

Eased edge T&B on all tops

A-4

**BLDG PERMIT PLANS** FILE Copy of Record

DATE:

1/20/2025

Cabinetry


DD

Creative Kitchens and 5610 Gulf of Mexico I Longboat Key, FL

SCALE:

@ 24"×36"

SHEET:

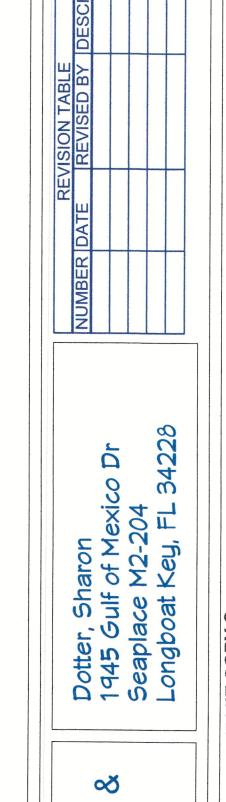


Sabinetry Layout / Bathrooms


DATE: 1/20/2025


SCALE:

@ 24" × 36"

SHEET:

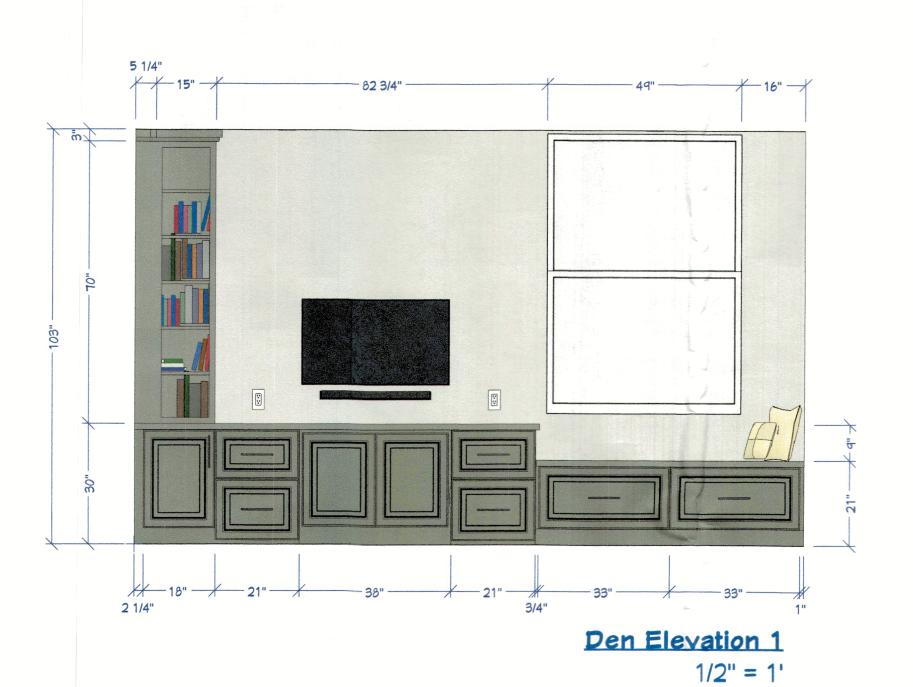

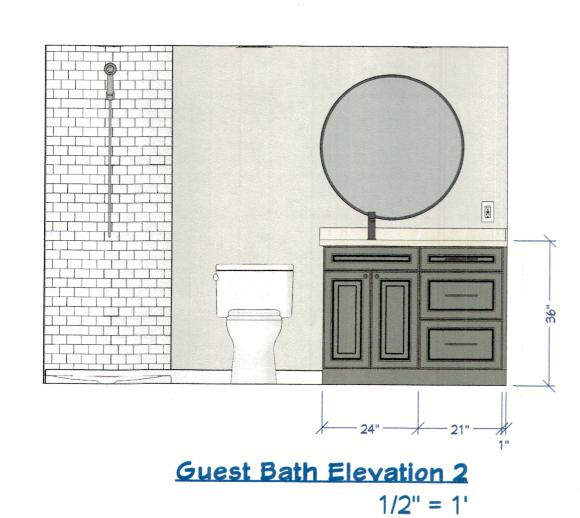

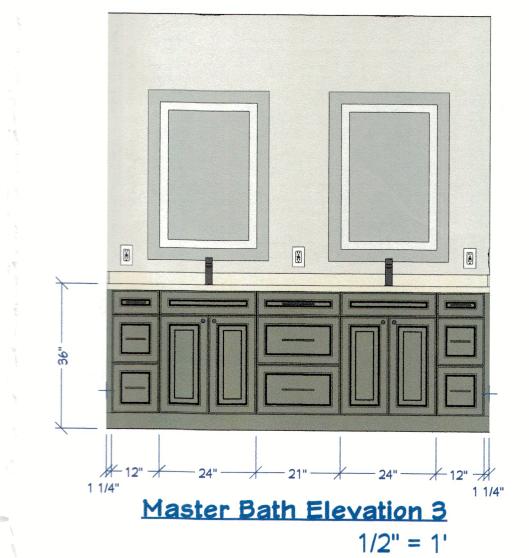







Renderings for Illustration No Scale

# Den and Bathroom Layout

121B1221 SB2421 3DB2121 SB2421 3DB1 BF

MBE3

1/2" = 1'

### Wall Legend

CMU Block Interior Wall

Demo Wall

New Wall

Glass


CABINETRY NOTES:

 
1. ALL CABINETS IN MAPLE CONFIRM COLOR WITH HOME OWNER PRIOR TO


FILLED AND PAINTED TO MATCH.

6. INSTALL HARDWARE ON SITE. 7. INSTALL CROWN MOLDING ON SITE; MATCH CABINET COLOR; CONFIRM PROFILE

8. CONFIRM FINAL MATERIALS FOR BACKSPLASH AND COUNTERTOP WITH HOME OWNER PRIOR TO ORDERING

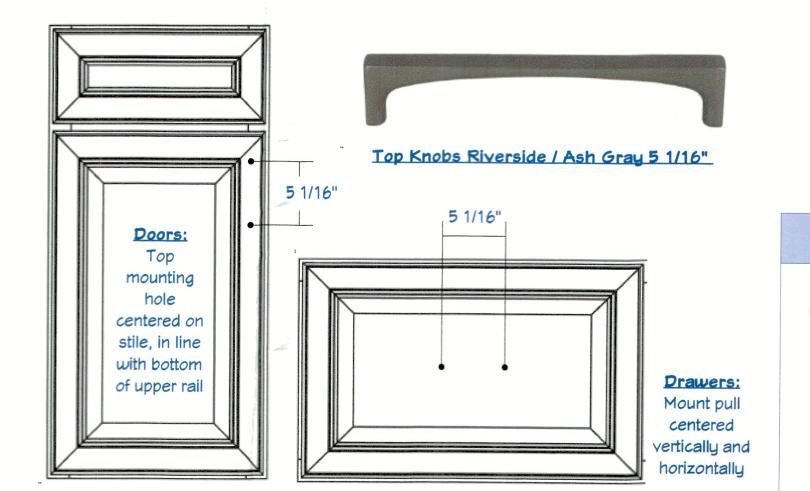



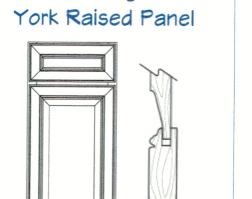

Frappe / Maple





Eased edge T&B on all tops

BLDG PERMIT PLANS

FILE Copy of Record


IAN 2 0 2025

TOWN OF LONGBOAT KEY Planning, Zoning & Building

2. ALL CABINETRY TO BE ATTACHED WITH 2 1/2" WOOD SCREWS TO STUDS.
3. INSTALL BACKING MATERIAL WHERE NECESSARY 4. ALL SCREW HEADS TO BE COVERED WITH FASTCAPS. ALL NAIL HOLES TO BE

5. CONFIRM DOOR & DRAWER STYLES WITH HOME OWNER PRIOR TO ORDERING.

AND DIMENSION WITH HOME OWNER.

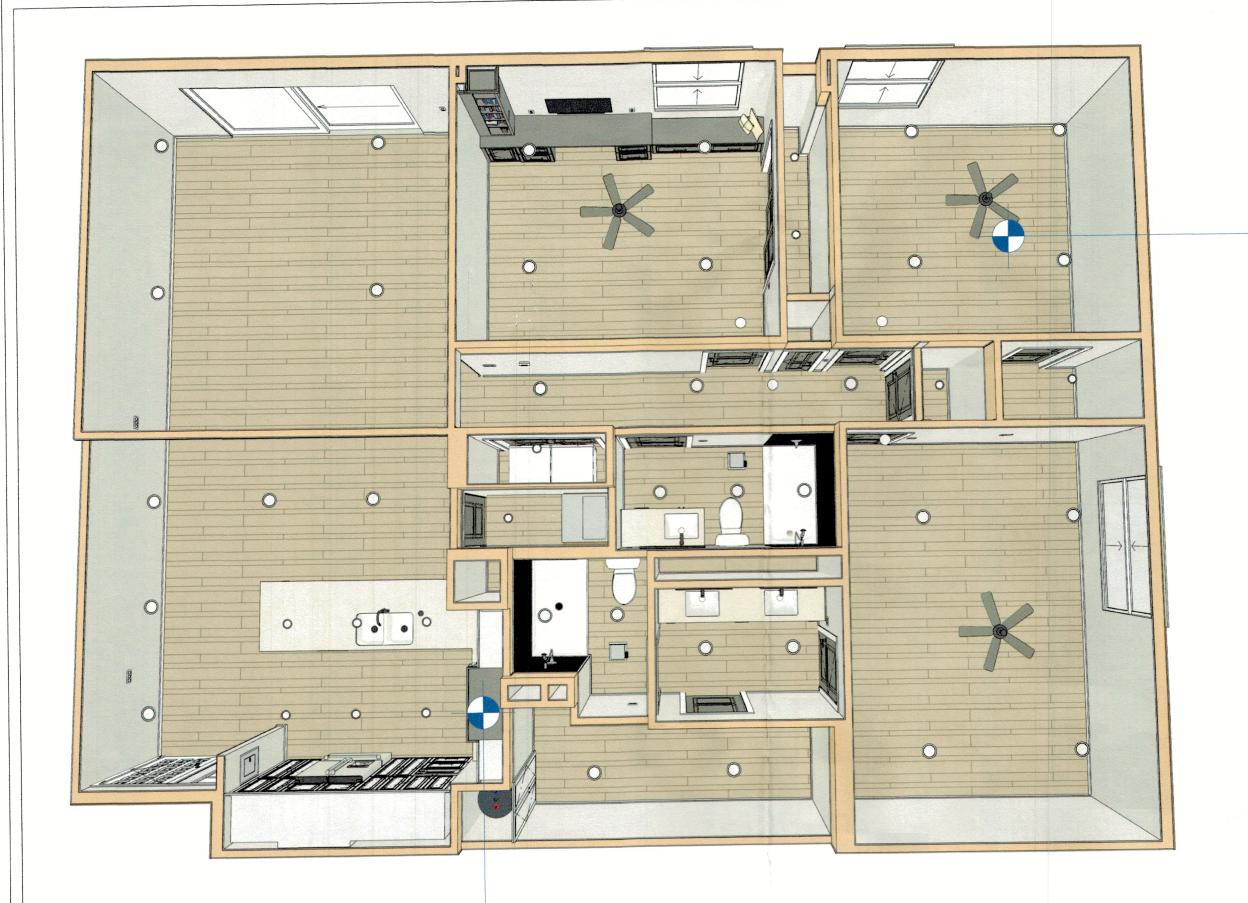

New LYP Flooring. Run parallel down hallway, throughout entire unit. Selection: TBD (Proposed - Provenza Moda Living First Crush)



Proposed: Happy Floors Touch Pearl


Kitchen Backsplash Tile

~15 sf Running Bond

Selection: TBD

Finish Material List

Flooring: ~1600 sf Baseboard: Standard Flat 6" ~417 If Casing: Standard Flat 3" ~472 If Jamb: Standard ~212 If

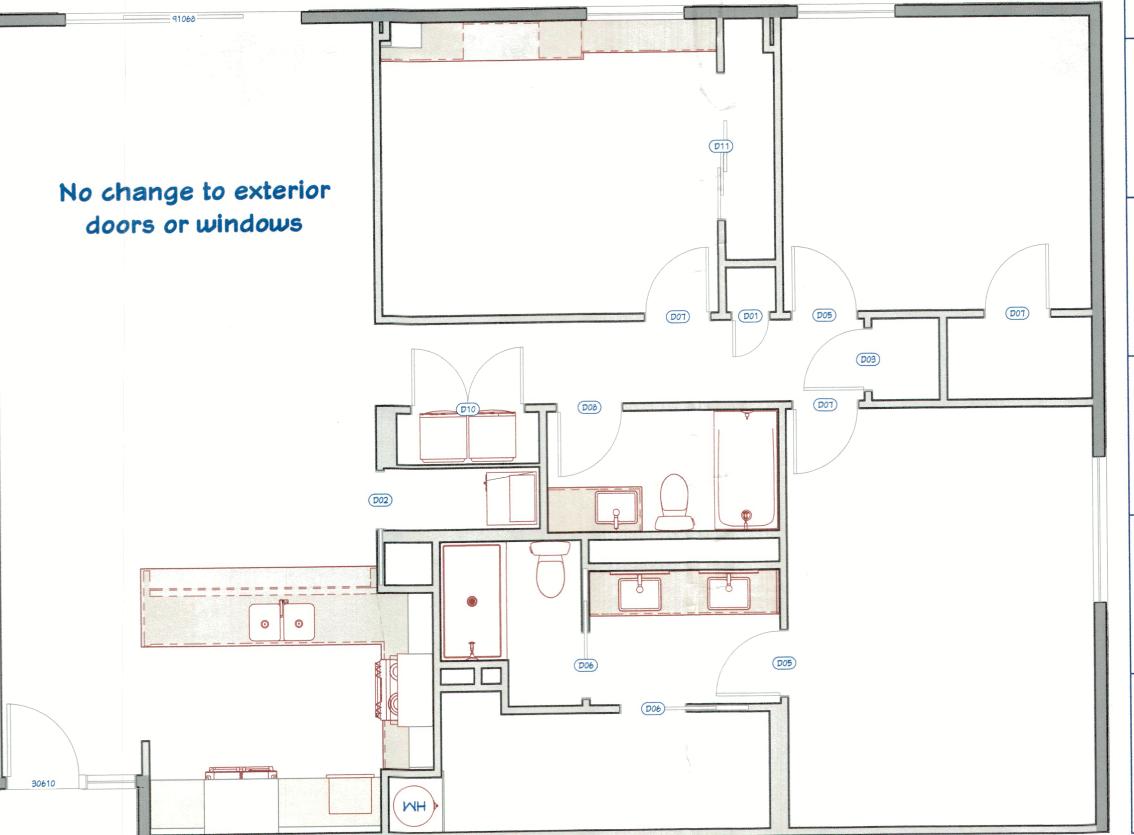


Appliance Specs									
Range:	Fridge:	Dishwasher:	Microwave:						
TBD	TBD	TBD	TBD						
	3								
	3 ·								
Hood:	Masher:	Dryer:							
TBD	TBD	TBD							

3D EXTERIOR ELEVATION	NUMBER	LABEL	QTY	FLOOR	SIZE	RIO	DESCRIPTION	HEADER	CODE	MANUFACTURER	COMMENTS
	D01	1668	1	1		20"X82 1/2"	HINGED-DOOR P04	2"×6"×20" (2)			
	D02	2468	1	1	2468 R	57 1/4"X82 1/2"	POCKET-DOOR P04	2"×6"×60 1/4" (2)			
	D03	2668	1	1	2668 L IN	<b>32</b> "×82 1/2"	HINGED-DOOR P04	2"×6"×32" (2)			
	D05	2868	2	1	2868 L IN	34"X82 1/2"	HINGED-DOOR P04	2"×6"×37" (2)			
	D06	2868	2	1	2868 R	65 1/4"×82 1/2"	POCKET-DOOR P04	2"×6"×68 1/4" (2)			
	D07	2868	3	1	2868 R IN	34"X82 1/2"	HINGED-DOOR P04	2"X6"X37" (2)			
	D08	2868	1	1	2868 R IN	34"X82 1/2"	HINGED-DOOR P04	2"X6"X34" (2)	В	LDG PERMI FILE Copy of R	T PLANS ecord
	<b>D</b> 10	4868	1	1	4868 L/R IN	58"×82 1/2"	DOUBLE HINGED-DOOR P04	2"×6"×61" (2)			
						104 - 1688 - 104 -					

0+3-PANEL SLIDER-DOOR P04 2"X8"X77" (2)

74"X82 1/2"



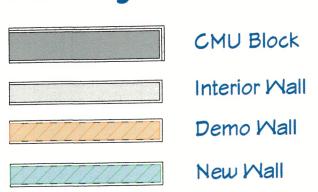

As Built

Schedule Finish

Creative Kitchens and Baths 5610 Gulf of Mexico Dr Longboat Key, FL

DATE: 1/20/2025

SCALE: @ 24"×36"

SHEET:

TOWN OF LONGBOAT KE Planning, Zoning & Building

A-6